



Location:  
 Administration Building  
 320 S. Walnut St  
 Appleton, WI 54911

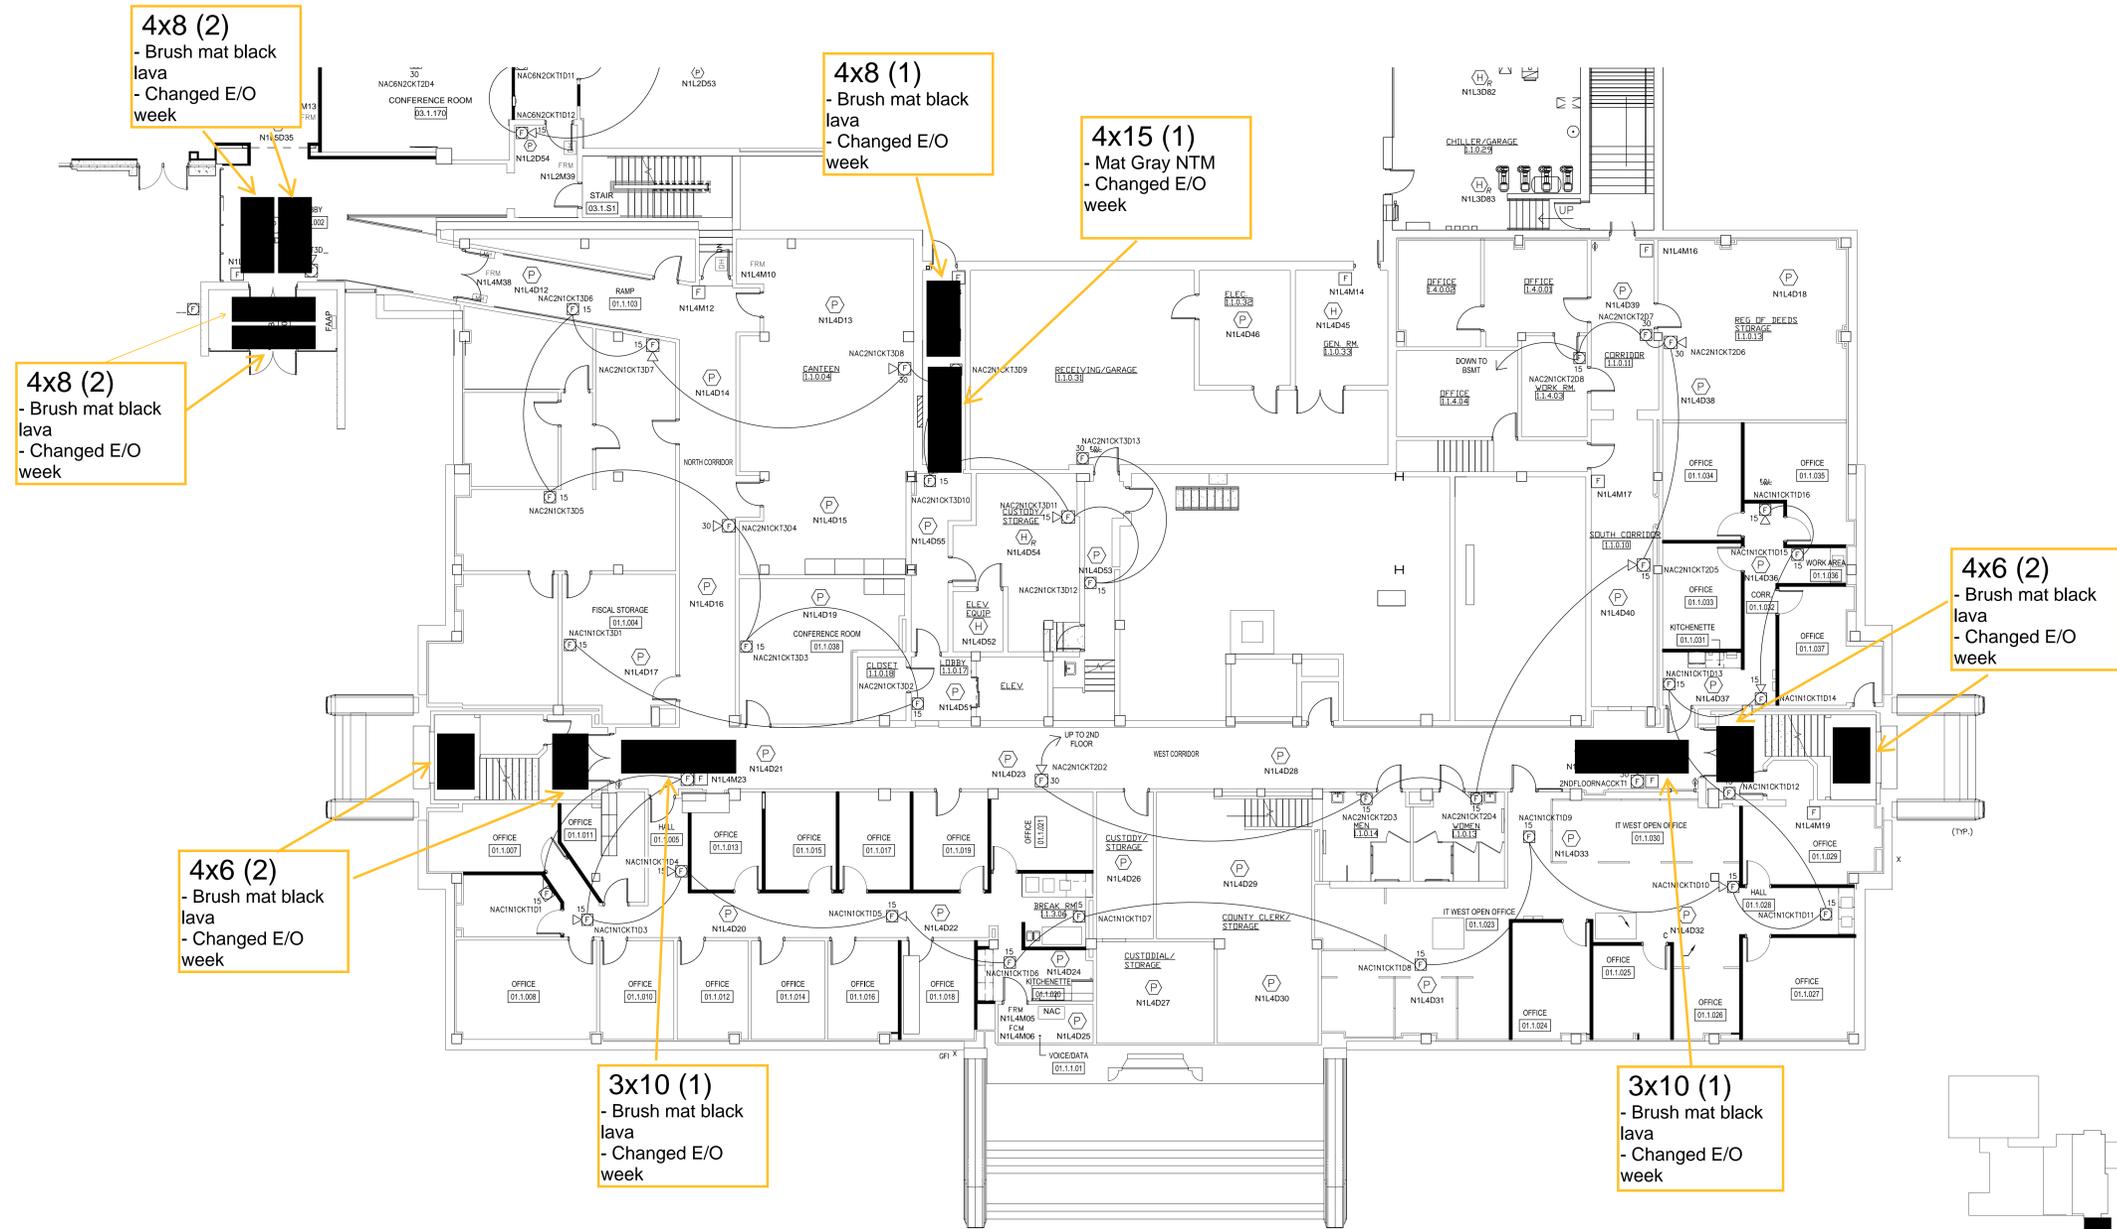

1 NORTH  
 1 FIRST FLOOR - AREA A  
 SCALE: 1/8"=1'-0"

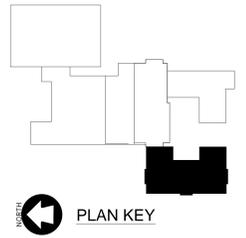

**LEGACY COMMUNICATIONS LLC**  
 4599 VETERANS AVENUE  
 SHERWOOD, WI 54169  
 PHONE 800-282-0526  
 FAX 920-439-1366  
 WWW.LEGACY-COMMUNICATIONS.COM  
 INFO@LEGACY-COMMUNICATIONS.COM

This drawing, data, and designs thereon shall not be duplicated, used or disclosed to others for procurement or other purpose except as otherwise authorized by contract, without written permission of Legacy Communications LLC. All reproductions shall bear this notice.

REVISION NUMBER	REVISION DESCRIPTION	REVISION DATE	REVISION BY
2	AS-BUILT	4-10-19	DUN
3	AS-BUILT	05-06-19	DUN
4	AS-BUILT	05-22-19	JLJ
5	AS-BUILT REVISIONS	06-29-20	DUN
6	AS-BUILT	08-07-20	DUN

CUSTOMER: OUTAGAMIE COUNTY ADMINISTRATION CENTER ADDITION / ALTERATION

TITLE: ADMIN BUILDING FIRST FLOOR PLAN - AREA A

APPROVAL:

DRAWN BY: DJN	DATE: 07-31-17
CHECKED BY: PT	SCALE: 1:1

DRAWING NUMBER: 8030-008


X:\368\customer\Outagamie County\Master Drawings\CAC\6-29-2008\_009\_010.011.txdraw First Floor base plan from archiving 8/7/2020 9:55:46 AM DWG TO PDF.dwg

Location:  
 Administration Building  
 320 S. Walnut St  
 Appleton, WI 54911



W599 VETERANS AVENUE  
 SHERWOOD, WI 54169  
 PHONE 800-282-0526  
 FAX 920-439-1366  
 WWW.LEGACY-COMMUNICATIONS.COM  
 INFO@LEGACY-COMMUNICATIONS.COM

This drawing, data, and designs thereon shall not be duplicated, used or disclosed to others for procurement or other purpose except as otherwise authorized by contract, without written permission of Legacy Communications LLC. All reproductions shall bear this notice.

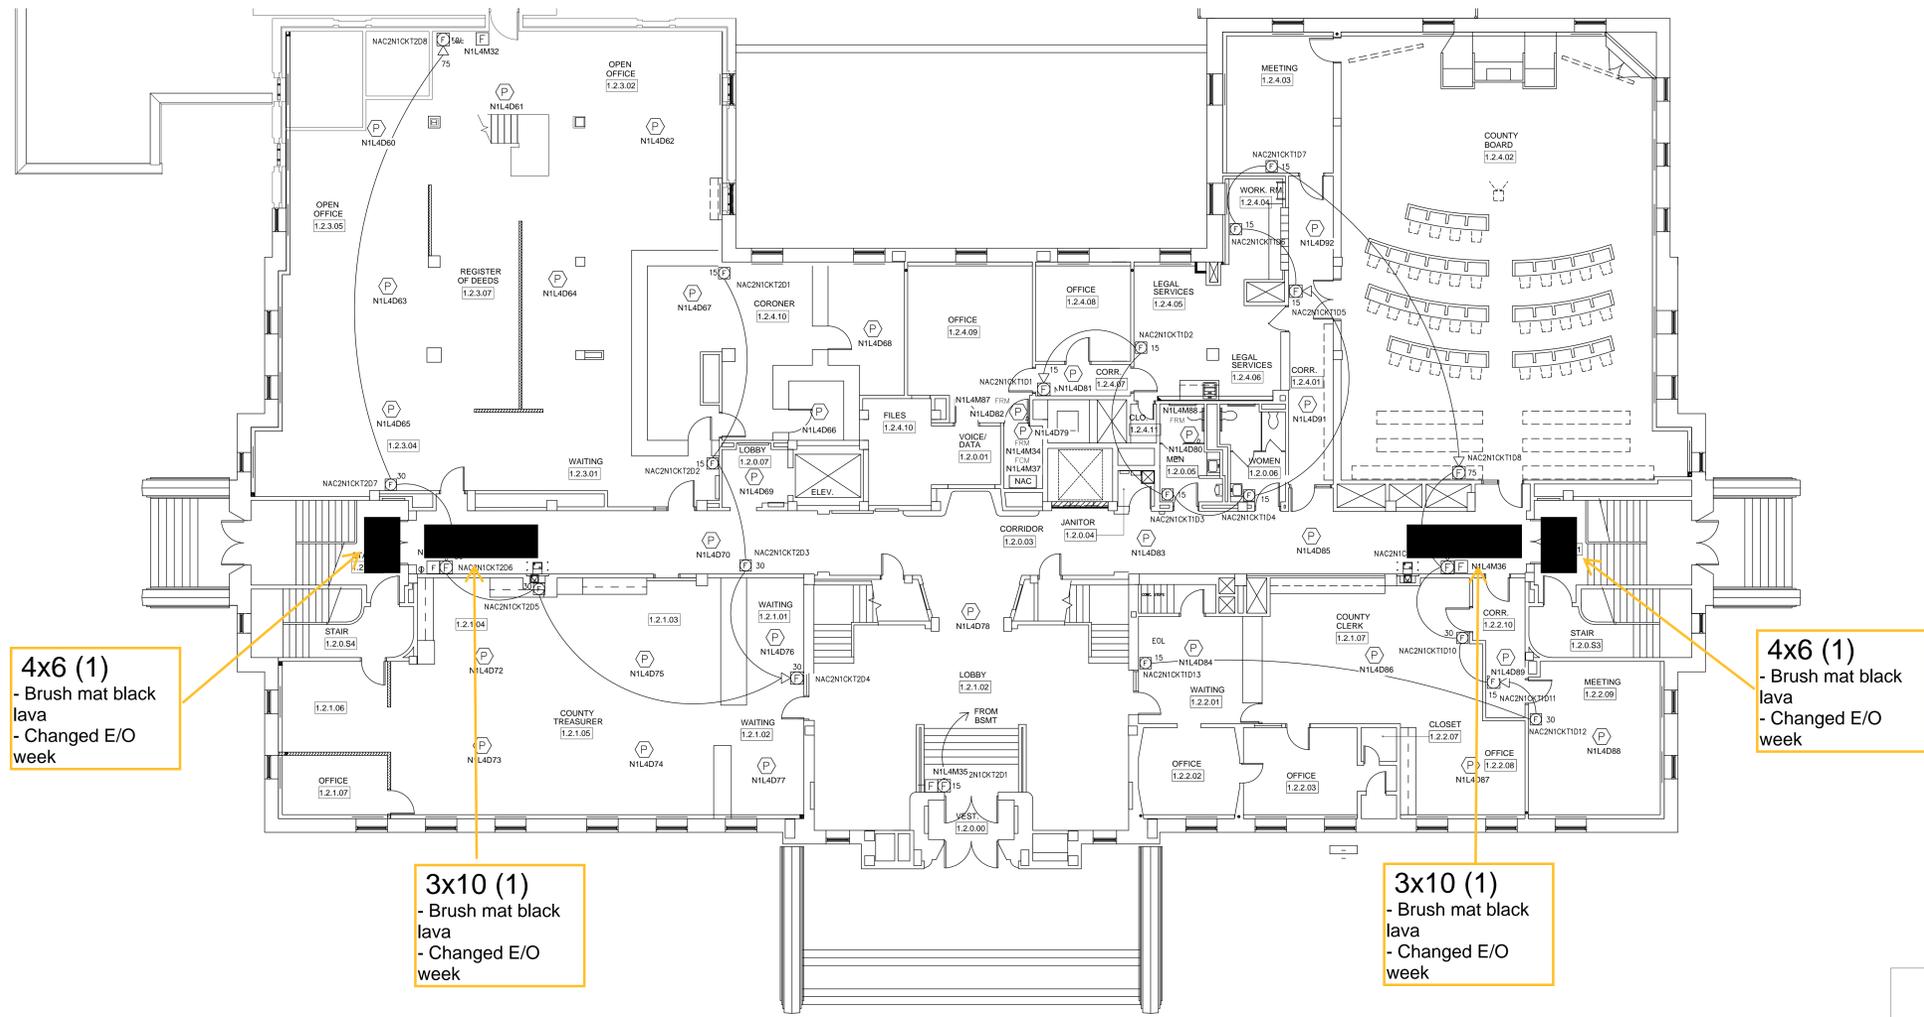

4x6 (1)  
 - Brush mat black lava  
 - Changed E/O week

3x10 (1)  
 - Brush mat black lava  
 - Changed E/O week

3x10 (1)  
 - Brush mat black lava  
 - Changed E/O week


4x6 (1)  
 - Brush mat black lava  
 - Changed E/O week

REVISION NUMBER	REVISION DESCRIPTION	REVISION DATE	REVISION BY
0	ORIGINAL	10-3-17	DJN
1	AS-BUILT	3-28-18	DJN
2	AS-BUILT	05-22-19	JLJ
3	AS-BUILT REVISIONS	06-29-20	DJN
4	AS-BUILT	08-07-20	DJN

CUSTOMER	
OUTAGAMIE COUNTY ADMINISTRATION CENTER ADDITION / ALTERATION	
TITLE	
ADMIN BUILDING SECOND FLOOR PLAN - AREA A	
APPROVAL	
DRAWN BY	DATE
DJN	07-31-17
CHECKED BY	SCALE
PT	1:1
DRAWING NUMBER	
8030-012	



1 SECOND FLOOR - AREA A  
 SCALE: 1/8"=1'-0"

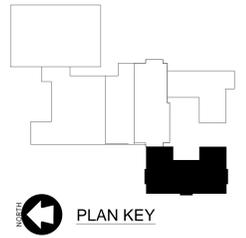

X:\368\customer\Outagamie County\Master Drawings\CAC-2-29-2017-015 overall Second floor base plan from archiwing\_07/2020\_10/28/15 AM DWG TO PDF.plt

**Location:**  
**Government Center**  
**320 S. Walnut St**  
**Appleton, WI 54911**

Green arrows =  
 seasonal mats



4x6 (1)  
 - Brush mat black  
 lava  
 - Changed E/O  
 week

4x8 (2)  
 - Brush mat black  
 lava  
 - Changed E/O  
 week

4x6 (2)  
 - Brush mat black  
 lava  
 - Changed E/O  
 week

4x6 (1)  
 - Brush mat black  
 lava  
 - Changed E/O  
 week

3x10 (1)  
 - Brush mat black  
 lava  
 - Seasonal only  
 - Changed E/O  
 week

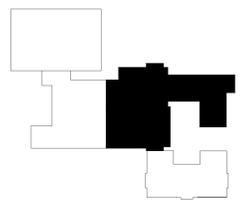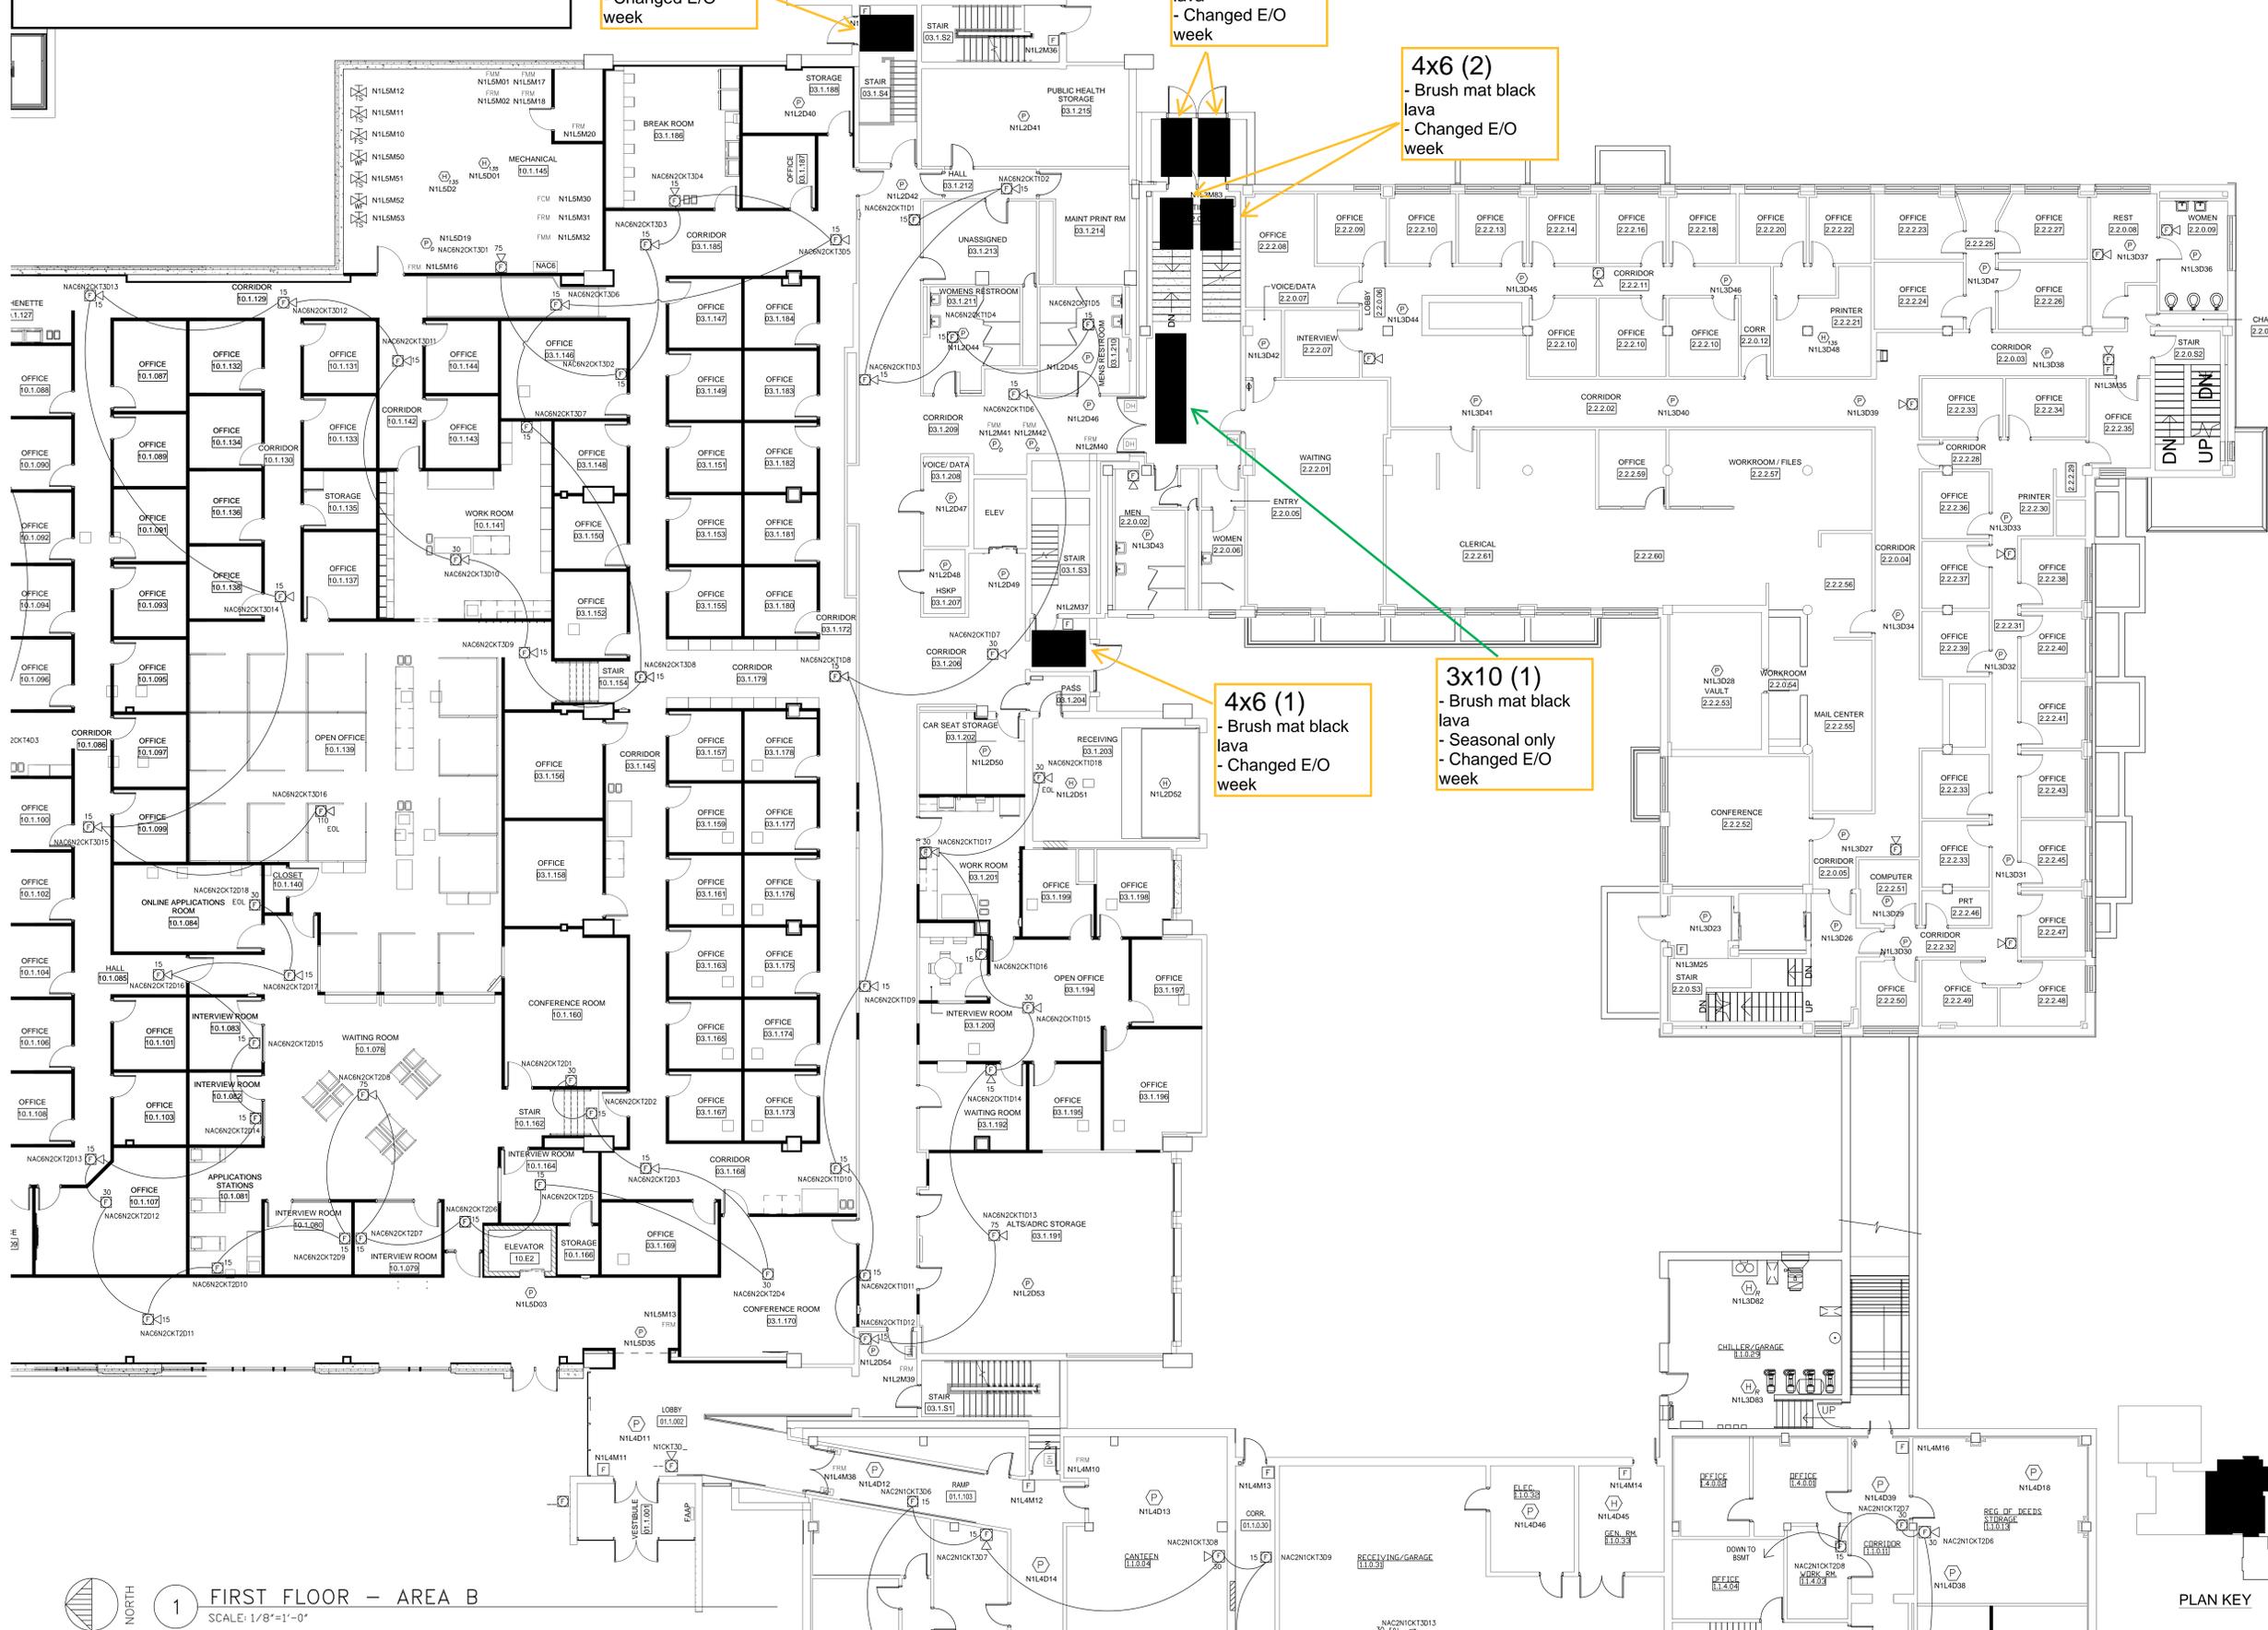

PLAN KEY

**LEGACY**  
 COMMUNICATIONS LLC

5599 VETERANS AVENUE  
 SHERWOOD, WI 54169  
 PHONE 800-282-0526  
 FAX 920-439-1366  
 WWW.LEGACY-COMMUNICATIONS.COM  
 INFO@LEGACY-COMMUNICATIONS.COM

This drawing, data, and designs thereon shall not be duplicated, used or disclosed to others for procurement or other purpose except as otherwise authorized by contract, without written permission of Legacy Communications LLC. All reproductions shall bear this notice.

REVISION NUMBER	REVISION DESCRIPTION	REVISION DATE	REVISION BY
1	AS-BUILT	3-28-18	DJN
2	AS-BUILT	05-6-19	DJN
3	AS-BUILT	05-22-19	DLJ
4	AS-BUILT REVISIONS	06-29-20	DJN
5	AS-BUILT	08-07-20	DJN

CUSTOMER  
**OUTAGAMIE COUNTY  
 ADMINISTRATION  
 CENTER  
 ADDITION /  
 ALTERATION**

TITLE  
**OCAC  
 NORTH-SOUTH  
 BUILDING FIRST  
 FLOOR PLAN -  
 AREA B**

APPROVAL

DRAWN BY DJN	DATE 07-31-17
CHECKED BY PT	SCALE 1:1
DRAWING NUMBER 8030-009	

NORTH  
 1 FIRST FLOOR - AREA B  
 SCALE: 1/8"=1'-0"

PLAN KEY

X:\300\Customer\Outagamie County\Master Drawings\OCAC-20-20-008-009-010-011-Overall First Floor base plan from archiving\_8/7/2020 9:59:57 AM DWG To PDF.dwg

Location:  
 Government Center  
 320 S. Walnut St  
 Appleton, WI 54911



**LEGACY COMMUNICATIONS LLC**  
 4599 VETERANS AVENUE  
 SHERWOOD, WI 54169  
 PHONE 800-282-0526  
 FAX 920-439-1366  
 WWW.LEGACY-COMMUNICATIONS.COM  
 INFO@LEGACY-COMMUNICATIONS.COM

This drawing, data, and designs thereon shall not be duplicated, used or disclosed to others for procurement or other purpose except as otherwise authorized by contract, without written permission of Legacy Communications LLC. All reproductions shall bear this notice.


REVISION NUMBER	REVISION DESCRIPTION	REVISION DATE	REVISION BY
1	AS-BUILT	3-28-18	DJN
2	AS-BUILT	05-6-19	DJN
3	AS-BUILT	05-22-19	PLJ
4	AS-BUILT REVISIONS	06-29-20	DJN
5	AS-BUILT	08-07-20	DJN

CUSTOMER: OUTAGAMIE COUNTY ADMINISTRATION CENTER ADDITION / ALTERATION

TITLE: OCAC GOVERNMENT CENTER FIRST FLOOR PLAN - AREA C

APPROVAL: [Signature]

DRAWN BY: DJN	DATE: 07-31-17
CHECKED BY: PT	SCALE: 1:1
DRAWING NUMBER: 8030-010	

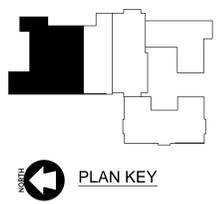


1 GOVERNMENT CENTER FIRST FLOOR - AREA C  
 SCALE: 1/8"=1'-0"

X:\300\3000\Outagamie County\Master Drawings\OCAC 6-29-2008\_009\_010.011 overall First Floor base plan from archiving\_8/7/2020 10:02:55 AM DWG TO PDF.dwg

Location:  
Justice Center  
320 S. Walnut St  
Appleton, WI 54911

4x6 (1)  
- Brush mat black  
lava  
- Changed E/O  
week

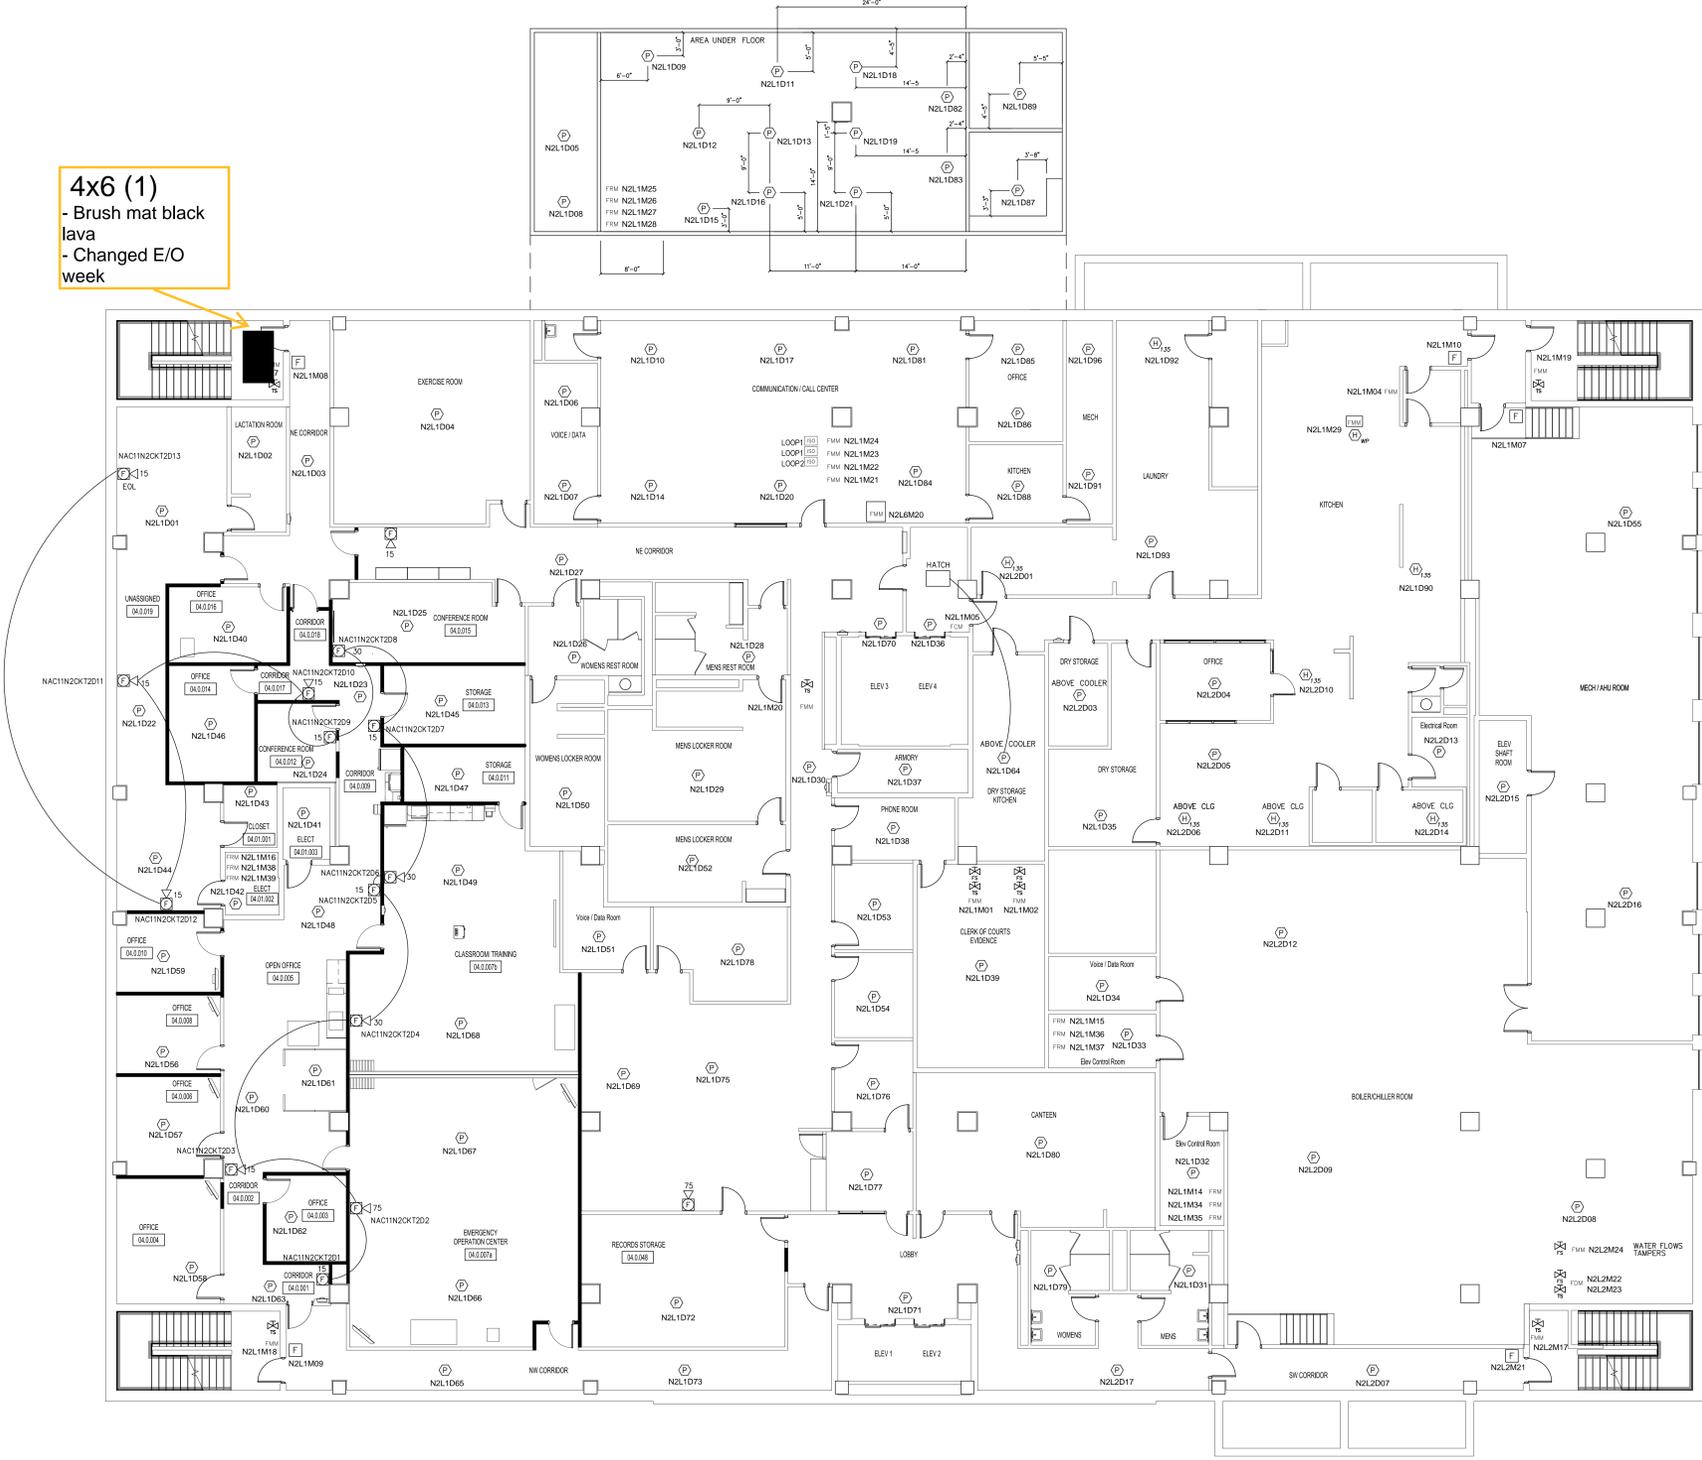

5599 VETERANS AVENUE  
SHERWOOD, WI 54189  
PHONE 800-282-0526  
FAX 920-439-1366  
WWW.LEGACY-COMMUNICATIONS.COM  
INFO@LEGACY-COMMUNICATIONS.COM

This drawing, data, and designs thereon shall not be duplicated, used or disclosed to others for procurement or other purpose except as otherwise authorized by contract, without written permission of Legacy Communications LLC. All reproductions shall bear this notice.

REVISION NUMBER	REVISION DESCRIPTION	REVISION DATE	REVISION BY
0	ORIGINAL	10-3-17	D/JN
1	AS-BUILT	05-22-19	J/LJ
2	AS-BUILT REVISIONS	06-29-20	D/JN
3	AS-BUILT	08-07-20	D/JN


CUSTOMER  
OUTAGAMIE COUNTY  
ADMINISTRATION  
CENTER  
ADDITION /  
ALTERATION

TITLE  
JUSTICE CENTER  
LOWER LEVEL -  
AREA D

APPROVAL	
DRAWN BY D/JN	DATE 07-31-17
CHECKED BY P/T	SCALE 1:1
DRAWING NUMBER 8030-007	



1 LOWER LEVEL - AREA D  
SCALE: 1/8"=1'-0"

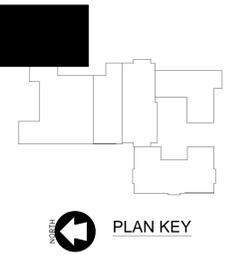

Location:  
Justice Center  
320 S. Walnut St  
Appleton, WI 54911

Green arrows =  
seasonal mats

3x10 (1)  
- Brush mat black  
lava  
- Changed E/O  
week

4x6 (1)  
- Brush mat black  
lava  
- Changed E/O  
week

3x10  
(2 seasonal)  
(1 normal)  
- Brush mat black  
lava  
- Changed E/O  
week

4x6 (1)  
- Brush mat black  
lava  
- Changed E/O  
week

4x6 (1)  
- Brush mat black  
lava  
- Changed E/O  
week

3x10 (1)  
- Brush mat black  
lava  
- Changed E/O  
week



5599 VETERANS AVENUE  
SHEBOYGAN, WI 53081  
PHONE 800-282-0526  
FAX 920-439-1366  
WWW.LEGACY-COMMUNICATIONS.COM  
INFO@LEGACY-COMMUNICATIONS.COM

This drawing, data, and designs  
thereon shall not be duplicated, used  
or disclosed to others for  
procurement or other purpose except  
as otherwise authorized by contract,  
without written permission of Legacy  
Communications LLC. All reproductions  
shall bear this notice.

REVISION NUMBER	REVISION DESCRIPTION	REVISION DATE	REVISION BY
1	AS-BUILT	3-28-18	DJN
2	AS-BUILT	05-6-19	DJN
3	AS-BUILT	05-22-19	JLJ
4	AS-BUILT REVISIONS	06-29-20	DJN
5	AS-BUILT	08-07-20	DJN

CUSTOMER  
OUTAGAMIE  
COUNTY  
ADMINISTRATION  
CENTER  
ADDITION /  
ALTERATION

TITLE  
OCAC  
JUSTICE CENTER  
FIRST FLOOR PLAN  
- AREA D

APPROVAL

DRAWN BY DJN	DATE 07-31-17
CHECKED BY PT	SCALE 1:1
DRAWING NUMBER 8030-011	



1 OCAC JUSTICE CENTER FIRST FLOOR - AREA D  
SCALE: 1/8"=1'-0"




PLAN KEY

Location:  
Justice Center  
320 S. Walnut St  
Appleton, WI 54911

Green arrows =  
seasonal mats

4x6 (1)  
- Brush mat black  
lava  
- Changed E/O  
week

3x10 (2)  
- Brush mat black  
lava  
- Changed E/O  
week

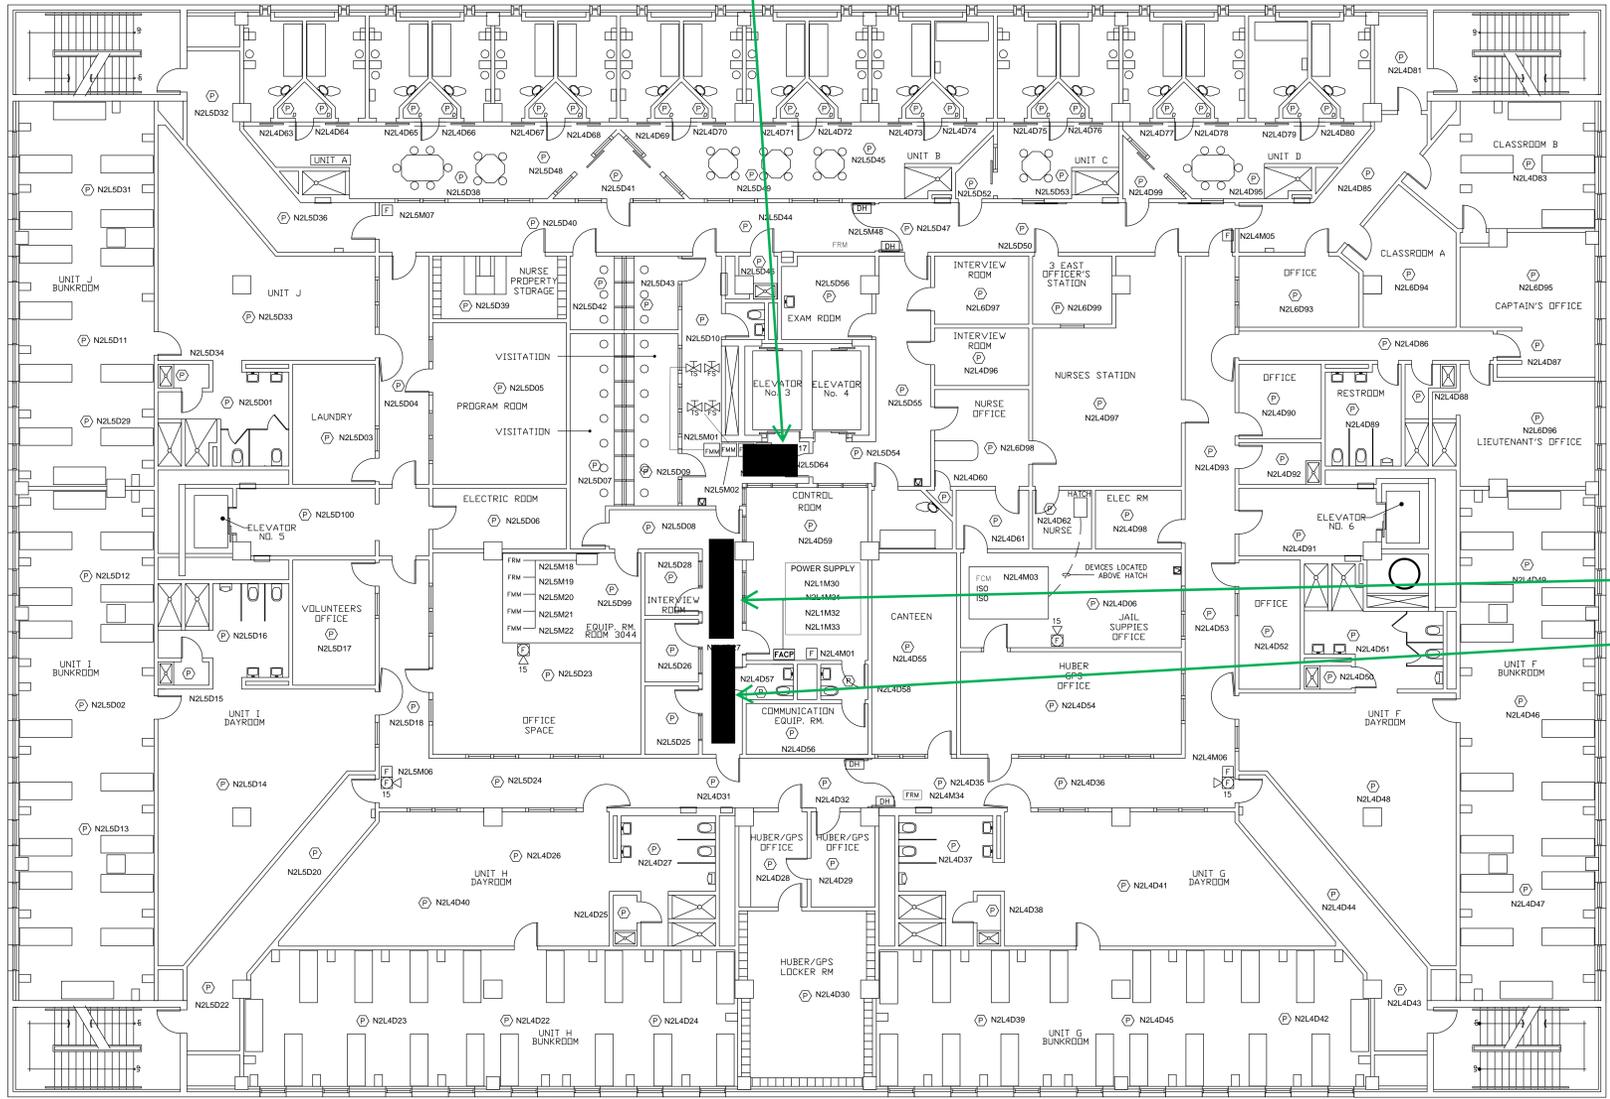

5599 VETERANS AVENUE  
SHERWOOD, WI 54169  
PHONE 800-282-0526  
FAX 920-439-1366  
WWW.LEGACY-COMMUNICATIONS.COM  
INFO@LEGACY-COMMUNICATIONS.COM

This drawing, data, and designs thereon shall not be duplicated, used or disclosed to others for procurement or other purpose except as otherwise authorized by contract, without written permission of Legacy Communications LLC. All reproductions shall bear this notice.

REVISION NUMBER	REVISION DESCRIPTION	REVISION DATE	REVISION BY
1	AS-BUILT	3-28-18	DJN
2	AS-BUILT	05-6-19	DJN
3	AS-BUILT	05-22-19	JLJ
4	AS-BUILT REVISIONS	06-29-20	DJN
5	AS-BUILT	08-07-20	DJN

CUSTOMER  
OUTAGAMIE COUNTY  
ADMINISTRATION  
CENTER  
ADDITION /  
ALTERATION

TITLE  
OCAC  
JUSTICE CENTER  
THIRD FLOOR PLAN  
- AREA D

APPROVAL


DRAWN BY  
DJN

DATE  
07-31-17

CHECKED BY  
PT

SCALE  
1:1

DRAWING NUMBER  
8030-021

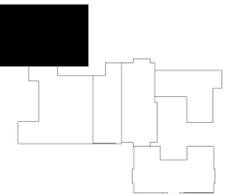

PLAN KEY



1



JUSTICE CENTER THIRD FLOOR - AREA D

SCALE: 1/8"=1'-0"

Location:  
Justice Center  
320 S. Walnut St  
Appleton, WI 54911

Green arrows =  
seasonal mats

4x6 (2)  
- Brush mat black  
lava  
- Changed E/O  
week

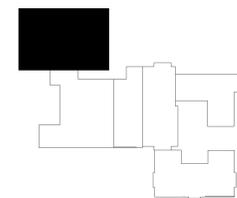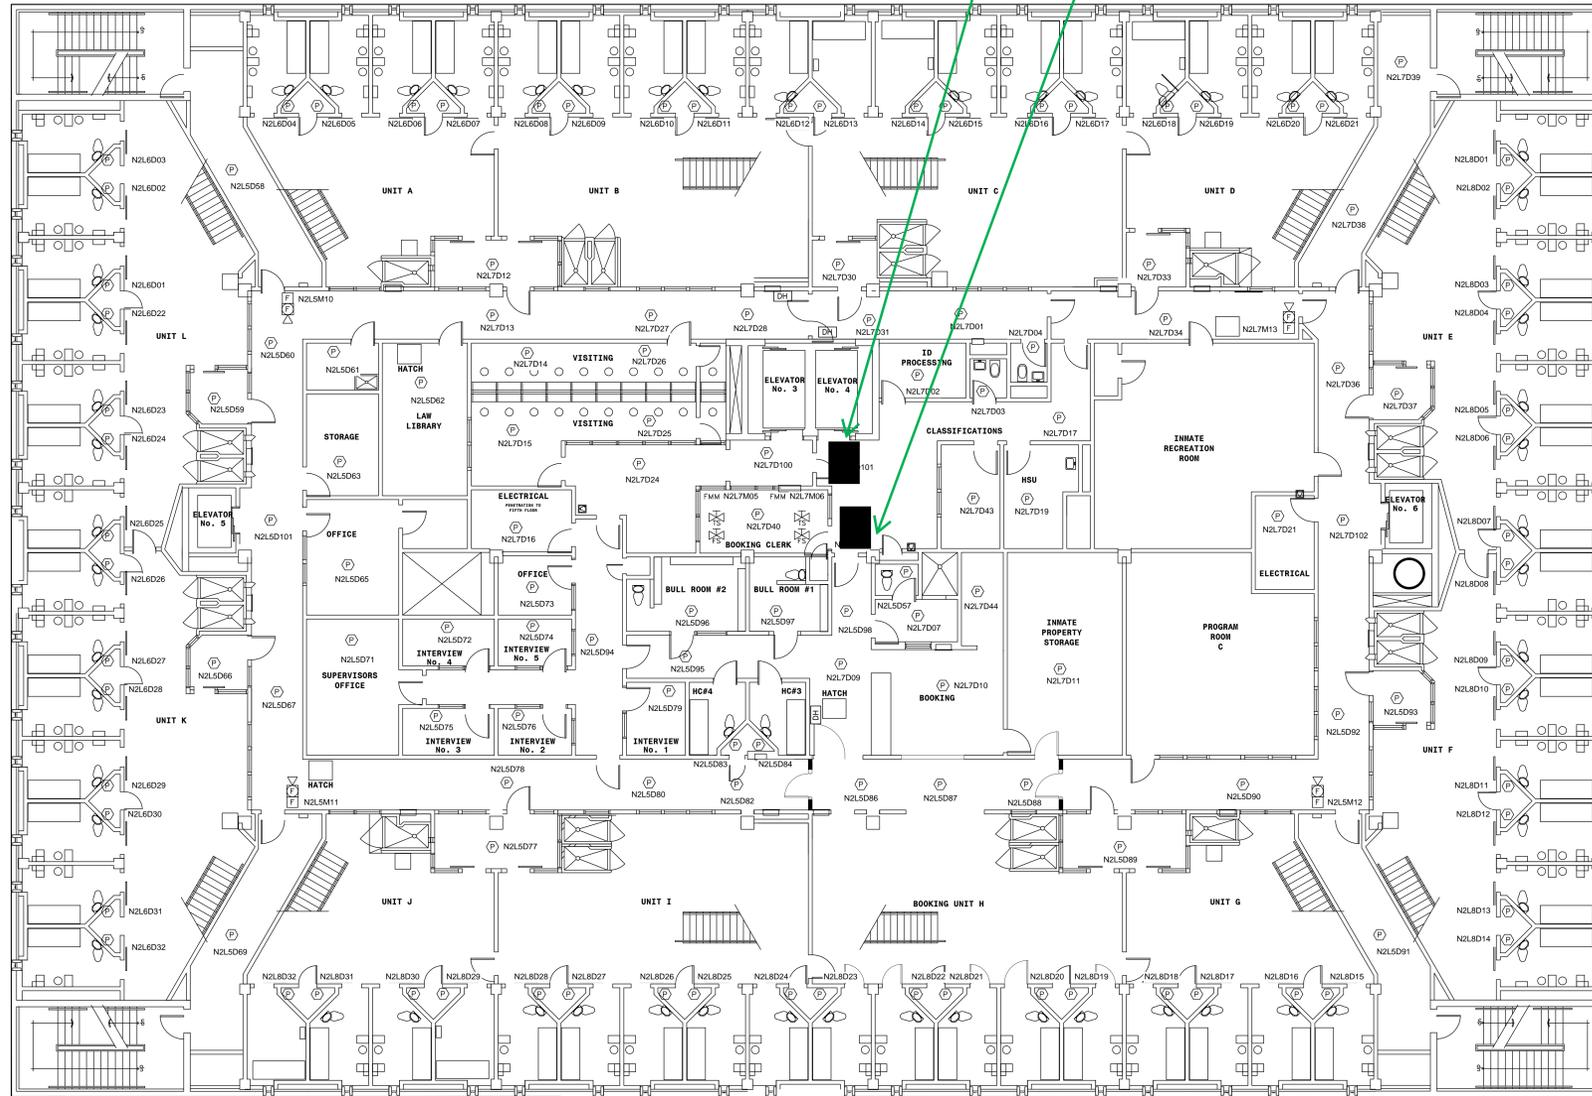

PLAN KEY



5599 VETERANS AVENUE  
SHERWOOD, WI 54169  
PHONE 800-282-0526  
FAX 920-439-1366  
WWW.LEGACY-COMMUNICATIONS.COM  
INFO@LEGACY-COMMUNICATIONS.COM

This drawing, data, and designs thereon shall not be duplicated, used or disclosed to others for procurement or other purpose except as otherwise authorized by contract, without written permission of Legacy Communications LLC. All reproductions shall bear this notice.

REVISION NUMBER	REVISION DESCRIPTION	REVISION DATE	REVISION BY
5	PROPOSED CAMERA ADDITIONS	5-6-09	JB
6	AS BUILT CLARIFICATION	2-27-12	DJN
7	AS BUILT REVISIONS	11-27-17	DJN
8	AS-BUILT REVISIONS	06-29-20	DJN
9	AS-BUILT	08-07-20	DJN

CUSTOMER  
**OUTAGAMIE COUNTY JUSTICE CENTER**

TITLE  
**FIRE ALARM PLAN  
FOURTH FLOOR**


APPROVAL

DRAWN BY: JB DATE: 11-9-05

CHECKED BY: EP SCALE: 1/8" = 1'

DRAWING NUMBER  
**8030-022**

Location:  
 Youth & Family  
 Services Building  
 500 W. 5th St  
 Appleton, WI 54911

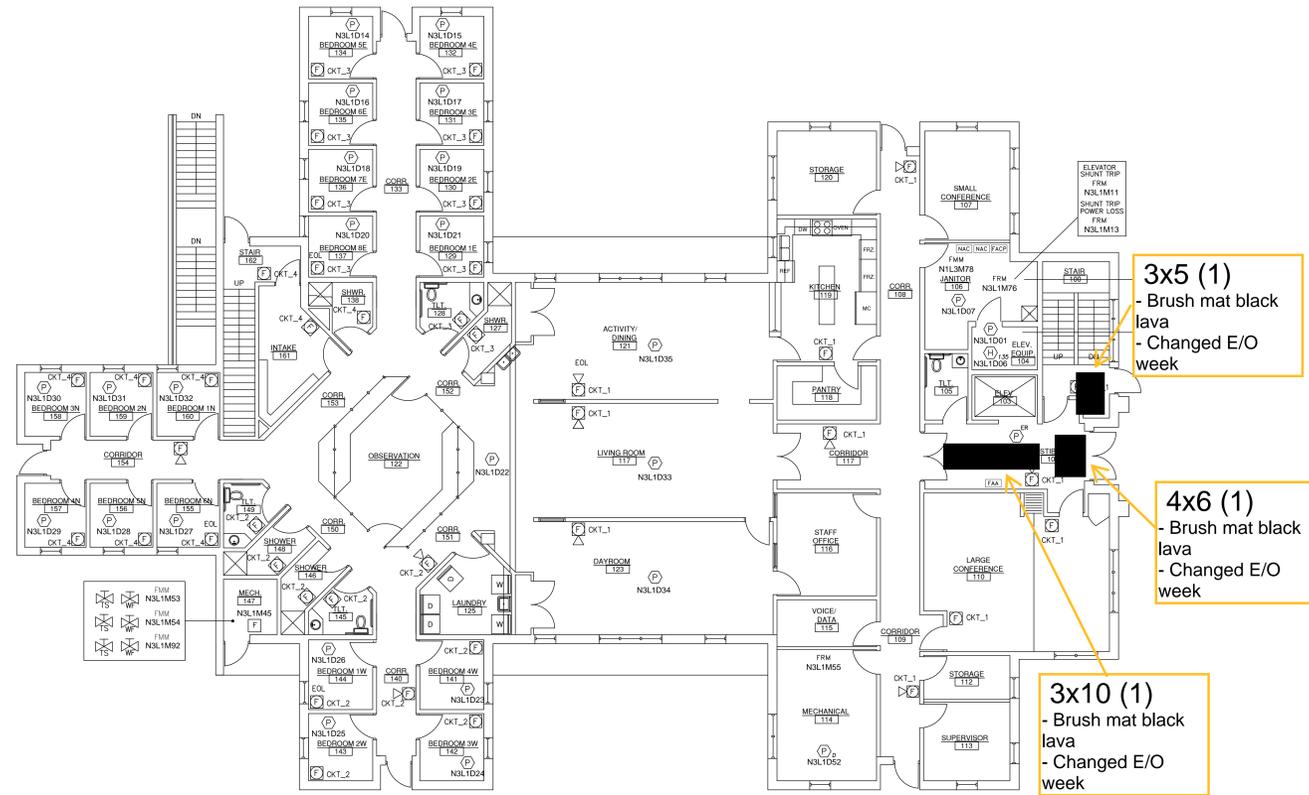

W599 VETERANS AVENUE  
 SHERWOOD, WI 54169  
 PHONE 800-282-0526  
 FAX 920-439-1366  
 WWW.LEGACY-COMMUNICATIONS.COM  
 INFO@LEGACY-COMMUNICATIONS.COM

This drawing, data, and designs thereon shall not be duplicated, used or disclosed to others for procurement or other purpose except as otherwise authorized by contract, without written permission of Legacy Communications LLC. All reproductions shall bear this notice.

REVISION NUMBER	REVISION DESCRIPTION	REVISION DATE	REVISION BY
0	ORIGINAL	XX-XX-XX	XXX
1	AS-BUILT	06-05-19	DJN
2	AS-BUILT REVISIONS	06-29-20	DJN
3	AS-BUILT	08-07-20	DJN

CUSTOMER  
 OUTAGAMIE COUNTY  
 YOUTH AND FAMILY  
 SERVICES

TITLE  
 FIRST FLOOR PLAN

APPROVAL

DRAWN BY  
 DJN

DATE  
 12-17-18

CHECKED BY  
 PT

SCALE  
 1:1

DRAWING NUMBER  
 8030-028

1 First Floor Plan  
 SCALE: 1/8" = 1'-0"



Location:  
 Maintenance Shop  
 410 S. Elm St  
 Appleton, WI 54911



W599 VETERANS AVENUE  
 SHERWOOD, WI 54169  
 PHONE 800-282-0526  
 FAX 920-439-1366  
 WWW.LEGACY-COMMUNICATIONS.COM  
 INFO@LEGACY-COMMUNICATIONS.COM

This drawing, data, and designs thereon shall not be duplicated, used or disclosed to others for procurement or other purpose except as otherwise authorized by contract, without written permission of Legacy Communications LLC. All reproductions shall bear this notice.

REVISION NUMBER	REVISION DESCRIPTION	REVISION DATE	REVISED BY
1	AS-BUILT	3-28-18	DJN
2	AS-BUILT	05-6-19	DJN
3	AS-BUILT	05-22-19	JLJ
4	AS-BUILT REVISIONS	06-29-20	DJN
5	AS-BUILT	08-07-20	DJN

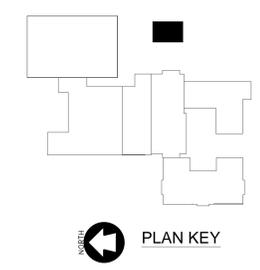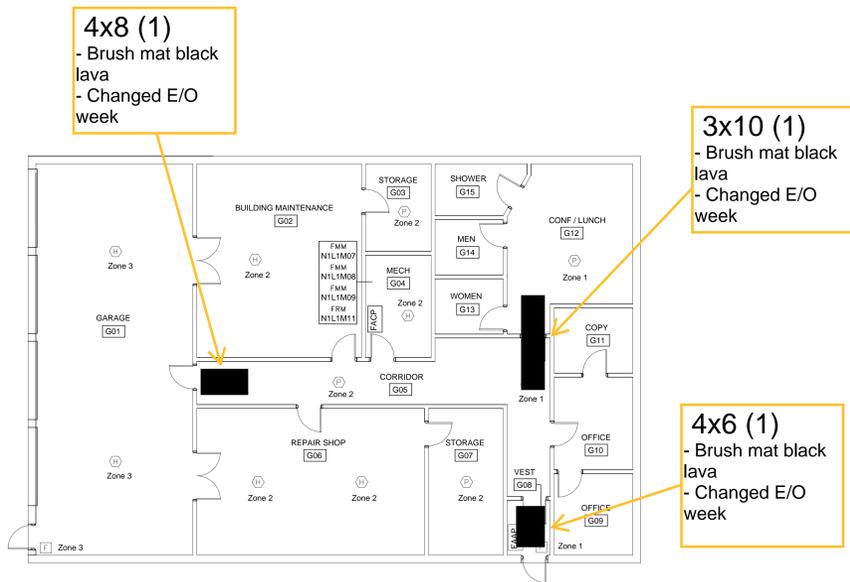

CUSTOMER	
OUTAGAMIE COUNTY ADMINISTRATION CENTER ADDITION / ALTERATION	
TITLE	
MAINTENANCE BUILDING	
APPROVAL	
DRAWN BY	DATE
DJN	07-31-17
CHECKED BY	SCALE
PT	1:1
DRAWING NUMBER	
8030-031	

X:\368\ByCustomer\Outagamie County\Master Drawings\CAC 6-29-2008\_009.010.011 overall First Floor base plan from archiving\_8/20/20 10:06:21 AM.dwg to 10/2/20

Location:  
 Sheriff's Dept  
 3030 E. Goodland Dr.  
 Appleton, WI 54911

Green arrows =  
 seasonal mats

Provide at this location:  
 - Shop short sleeve, gray, shirts  
 - Shop work pants  
 - Mechanic grade shop towels


3x10  
 (2 seasonal)  
 (2 normal)  
 - Brush mat black  
 lava  
 - Changed E/O  
 week

3x5 (1)  
 - Brush mat black  
 lava  
 - Changed E/O  
 week

3x10 (1)  
 - Brush mat black  
 lava  
 - Changed E/O  
 week

3x5 (1)  
 - Brush mat black  
 lava  
 - Changed E/O  
 week

4x6 (2)  
 - Brush mat black  
 lava  
 - Changed E/O  
 week

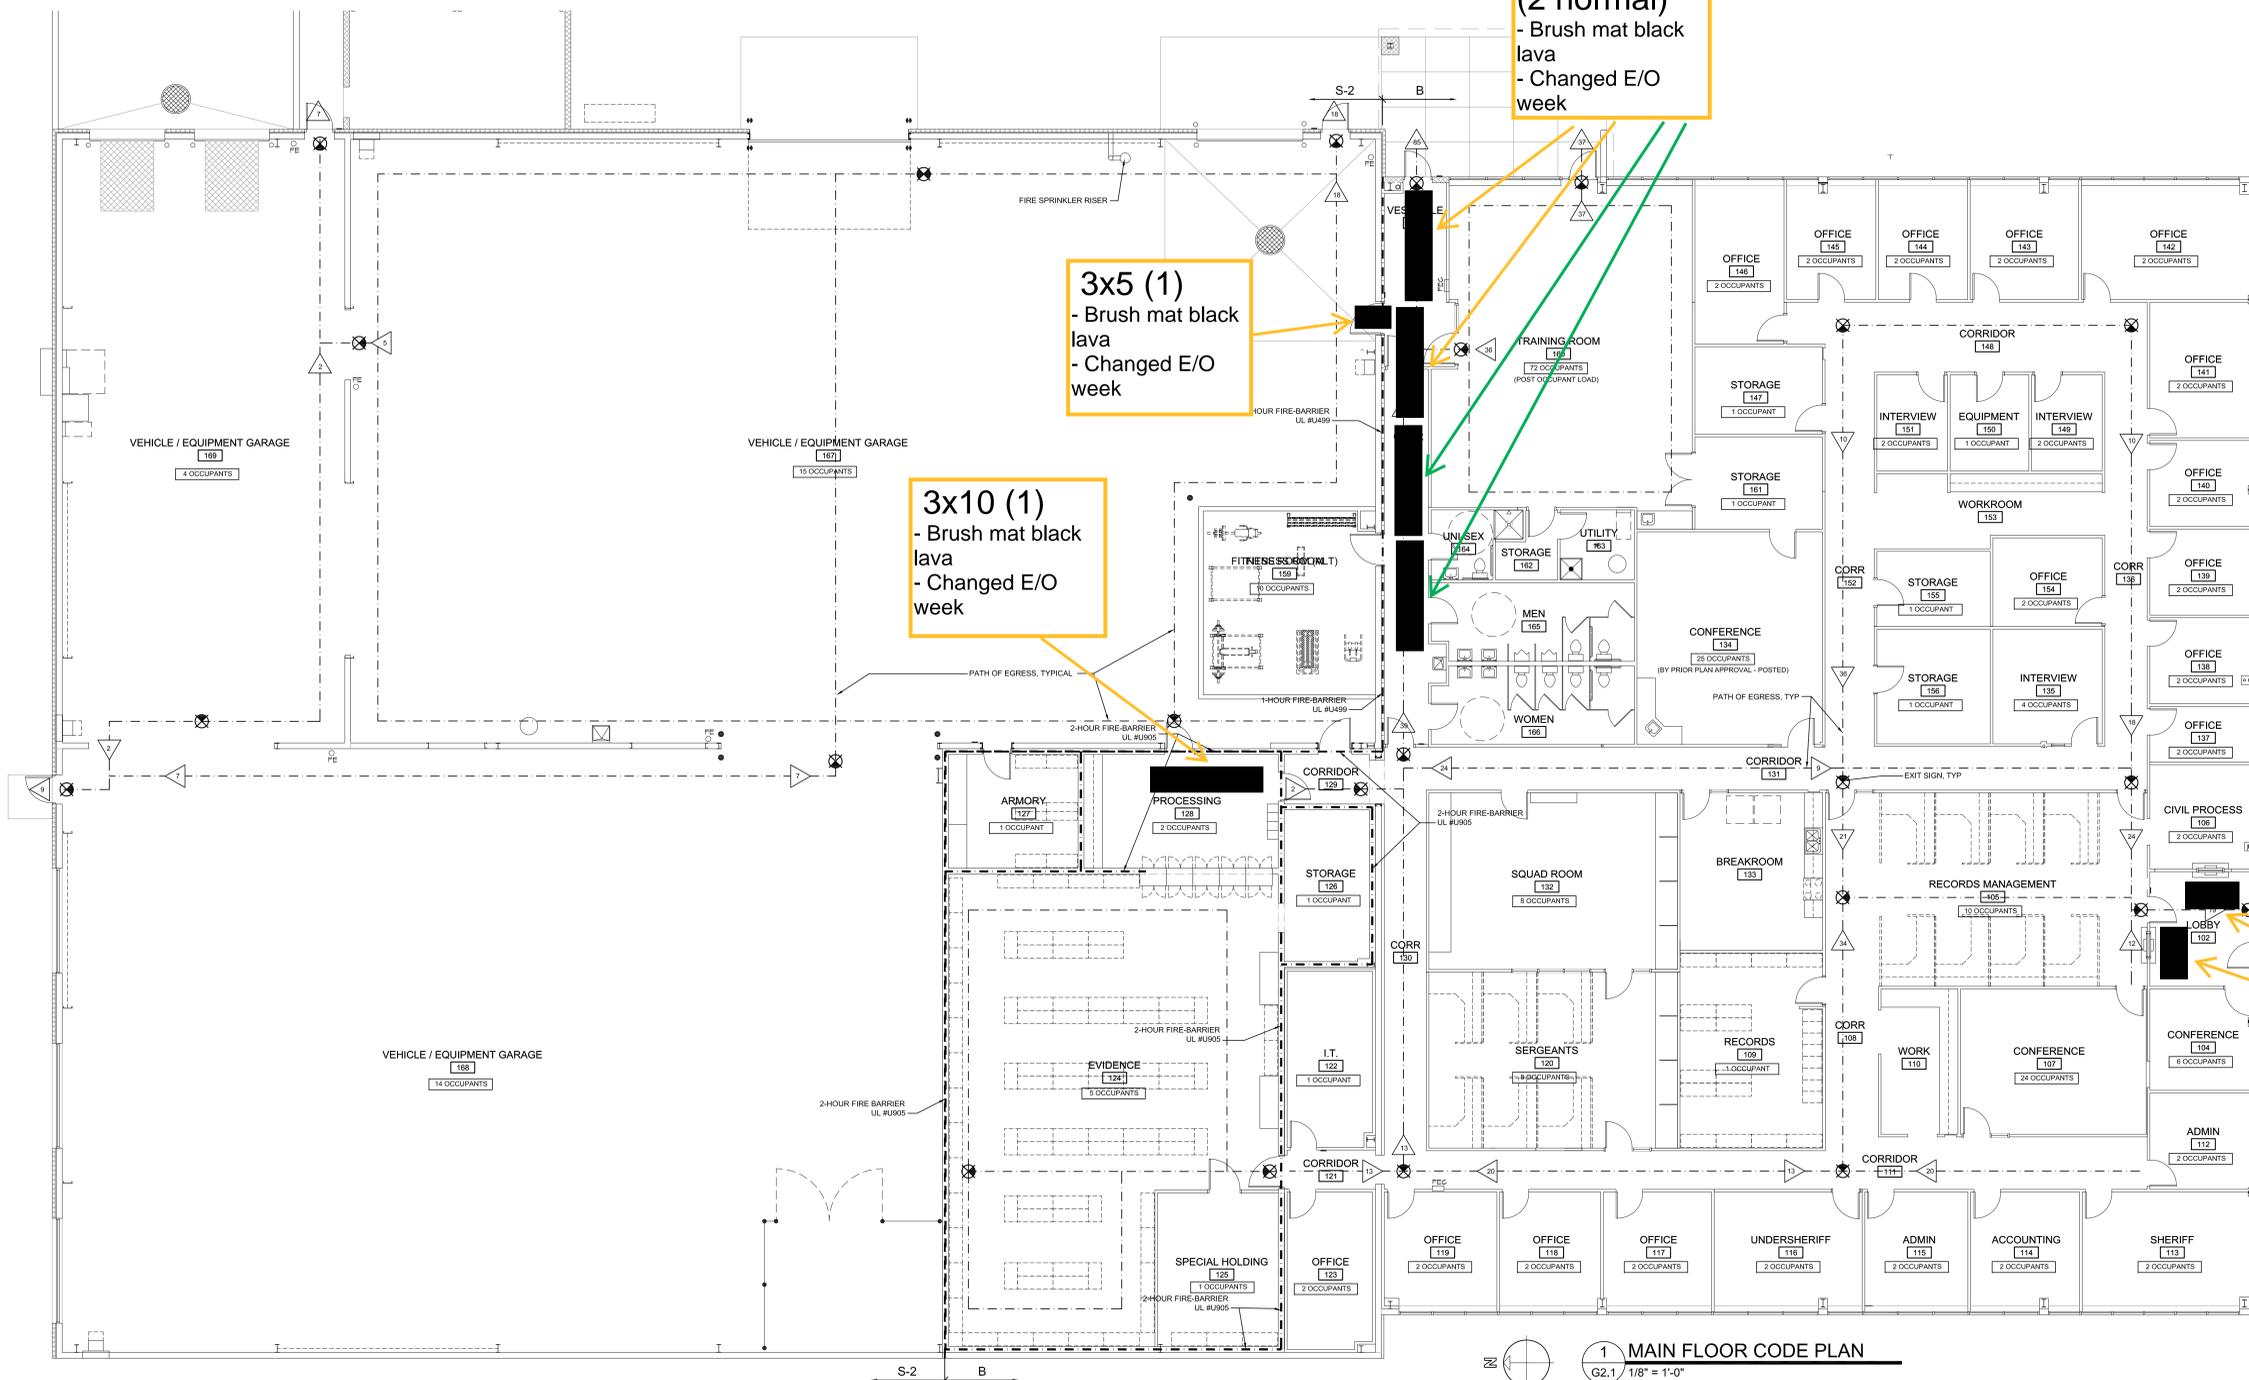

1 MAIN FLOOR CODE PLAN  
 G2.1 1/8" = 1'-0"

NO.	DATE	BY	CHKD	APPROVED	TGC	REVISION
1	4-15-17					

INTERIOR ALTERATION  
 OUTAGAMIE COUNTY  
 SHERIFF LAW ENFORCEMENT DIVISION  
 3030 EAST GOODLAND DRIVE - APPLETON, WI

SCALE	DATE
1/8" = 1'-0"	4 APRIL 2017
PROJECT NUMBER	
1-0915-001	
CODE PLAN AND NOTES	
DRAWING NO.	
G2.1	



**Location:**  
**UW Extension**  
**3365 W. Brewster St**  
**Appleton, WI 54914**



**MILLER  
 WAGNER  
 COENEN  
 McMAHON**  
 ARCHITECTS + ENGINEERS

250 NORTH GREEN BAY ROAD  
 NEENAH, WISCONSIN 54956  
 TEL: 414-725-6346  
 FAX: 414-725-5904

Green arrows =  
 seasonal mats


Blue arrows =  
 mats changed  
 monthly

**4x6 (1)**  
 - Brush Mat Black  
 Lava  
 - Changed  
 Monthly

**3x10 (1)**  
 - Brush Mat Black  
 Lava  
 - Changed  
 Monthly

**3x5 (1)**  
 - Brush Mat Black  
 Lava  
 - Changed  
 Monthly

**3x5 (1)**  
 - Brush Mat Black  
 Lava  
 - Changed  
 Monthly

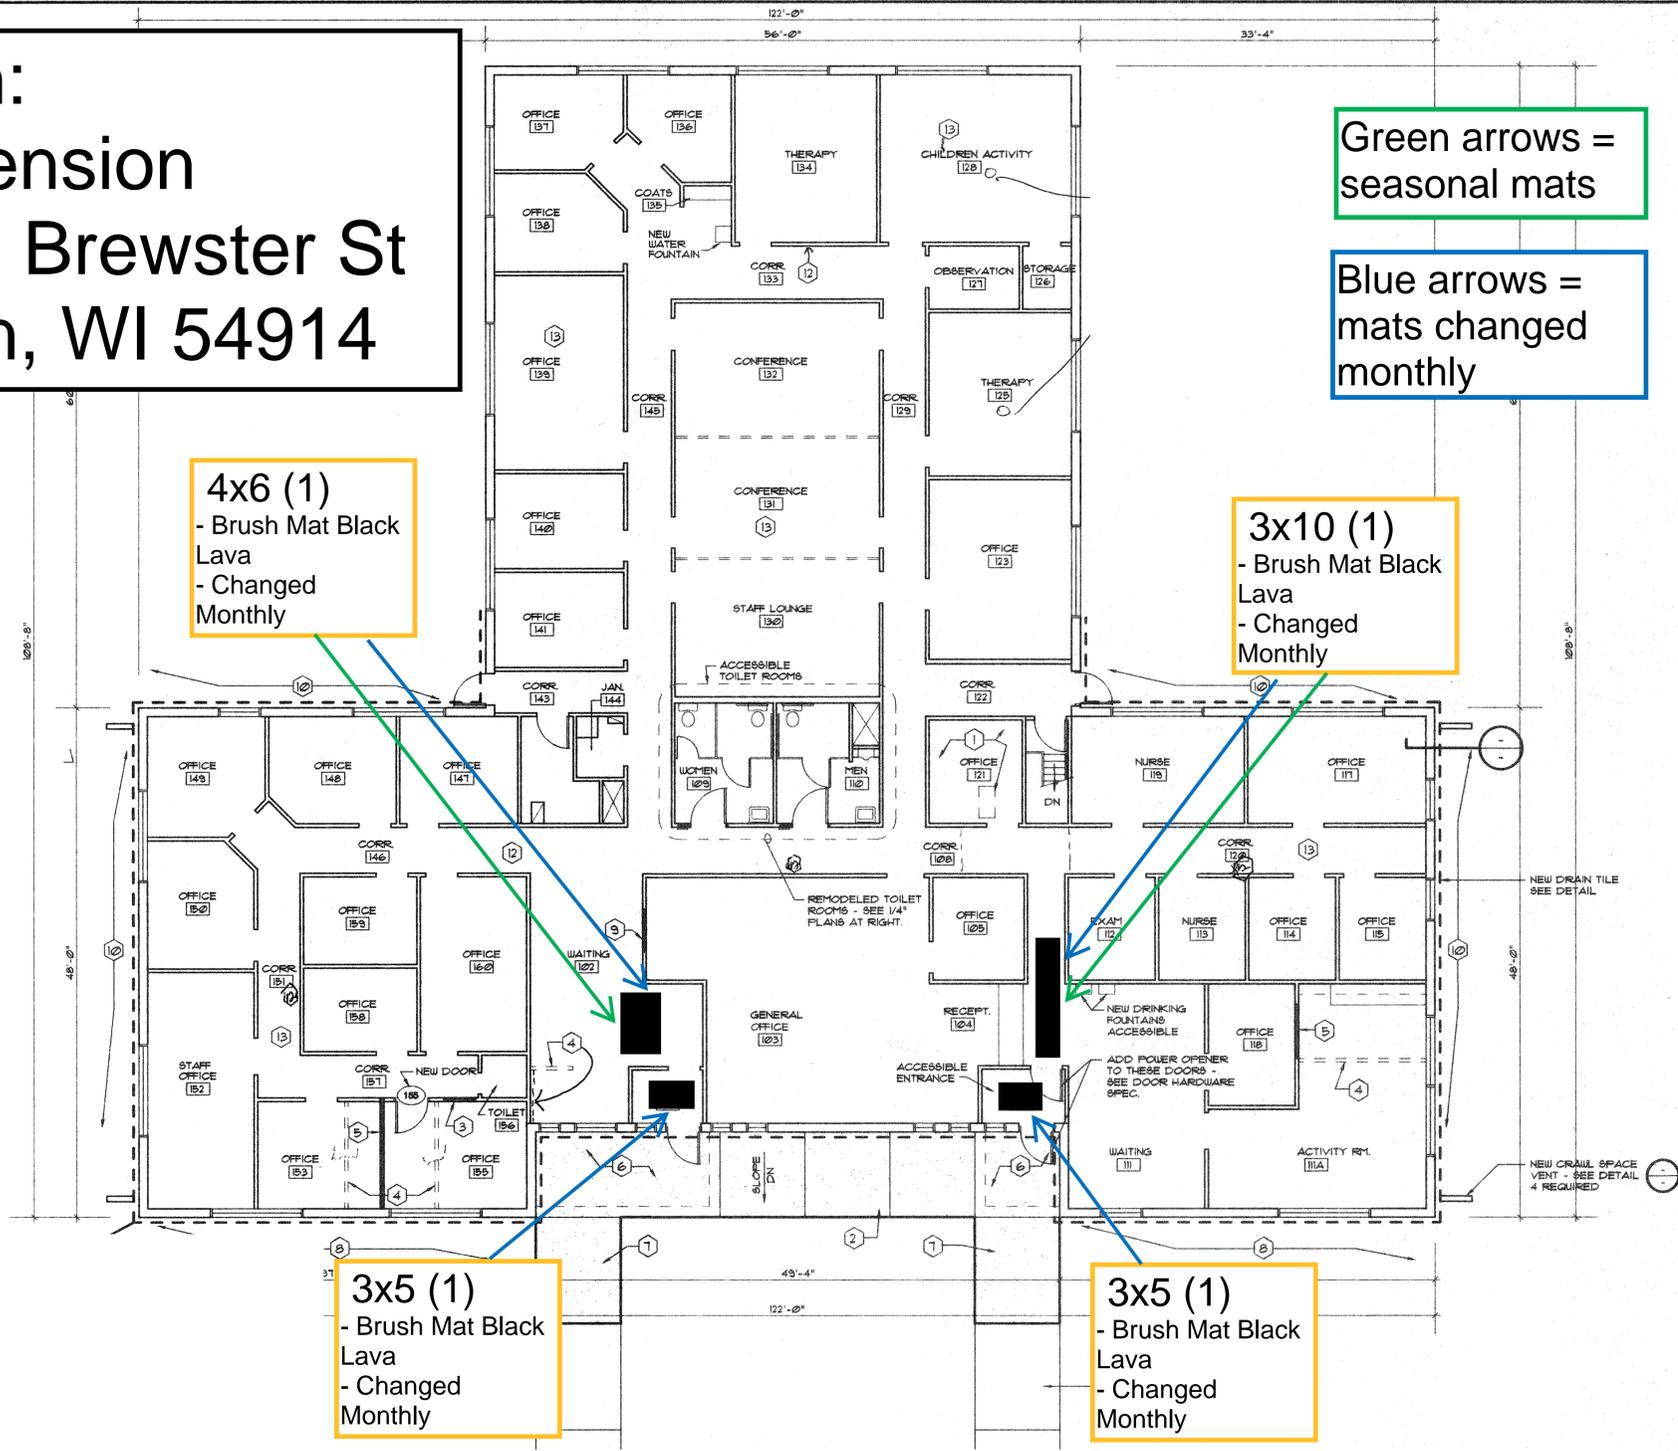

NO.	DATE	REVISION
DESIGNED	DRAWN	CHECKED
MLB	MLF	

**BREWSTER STREET FACILITY REMODELING**  
**FOR OUTAGAMIE COUNTY**  
**APPLETON, WISCONSIN**

DATE  
 MARCH, 1994

SHEET TITLE  
**FLOOR  
 PLAN**

SHEET NO.  
**A2**

FILE NO. PROJECT NO.  
 1502-63101.32